

Seventh Avenue at 27 Street New York City 10001-5992 www.fitnyc.edu Purchasing Department 227 West 27th Street New York, NY 10001 Purchasing Dept. Tel. 212-217-3630 Purchasing Dept. Fax 212-217-3631 **Purchasing@fitnyc.edu**

NOTICE TO ALL FIRMS

Date: June 20, 2025

To: All Prospective Bidders

From: Sam Li Director of Procurement Services

Re: Addendum Number 2 IFB # C1585R – Pomerantz New Fire Alarm System – Rebid

Questions

Q1. According to the specifications for the Duralife RHH cables, the attached charts shows the conduit fill which states 1-4 #3/0 conduits are to be in a 3°C, please note that the conduit size on drawing E-601 will not hold the Duralife conductors due to the insulation on the conductors, so the conduit size must increase. Please advise.

PECIFICATIONS DuraLife [®] RHH/R90 Two-Hour Fire-Rated Power Cables													
 EMT/Co Phenolio Pull Box 	onduit: Whe c Conduit: (atland/We Conduit & C 1: Eaton/C	tern Tube; S Couplings: (ooper; Type	IraLife [®] IIInstal Set-Screw Cou Champion Fib 4X: Nvent/H	ipling & F erglass; C	ittings:	Hubbell	Raco	2	020 NFF	°A 70°	Table 3	10.16
Radi	x Dı	uraLi	ife® F	owe	r Ca	able	es	Horizontal Installation- Champion EMT Raceway EMT Raceway Constitution- EMT Raceway Flame Shield Champion Flame Shield Champion Flame Shield Flame Shield Type XW Type XW					
DuraLife Part Number	Conductor Size	Conductor Strands	Overall Diameter	Insulation System Thickness	Approx. Weight (Ibs/1,000')	Ampacity 75°C (amps)	Ampacity 90°C (amps)	Number of Conductors		Number of Conductors		Number of Conductors	
								1 to 4	5	1 to 4	5	1 to 4	5
RH14A007	14 awg	7	.195*	45 mils	29	20	25	1*	1 %*	1.	1%*	1"	1 %*
RH12A007	12 awg	7	.220*	45 mils	38	25	30	1%"	1 %*	1%*	1%*	1"	1%
RH10A007	10 awg	7	.250*	45 mils	54	35	40	1 %*	1 %*	1 %*	1%*	1"	1%
RH08A007	8 awg	7	.310"	60 mils	84	50	55	1 %"	1 %*	1%*	1%*	1"	1%
RH06A007	6 awg	7	.380*	75 mils	131	65	75	1 %*	2*	1 ½*	2"	1 %"	1 %*
RH04A007	4 awg	7	.420*	75 mils	186	85	95	2"	2 ½*	2*	2 %*	1 %"	1 %*
RH03A007	3 awg	7	.450*	75 mils	225	100	115	2*	2 1/2*	2 ½*	2 %*	1 %"	2*
RH02A007	2 awg	7	.480*	75 mils	270	115	130	2"	2 %*	2 ½*	3"	1 %"	2*
RH01A019	1 awg	19	.560*	100 mils	365	130	145	2 ½*	3*	2 1/2*	3"	2 ½"	3*
RHX1A019	1/0	19	.600*	100 mils	443	150	170	2 ½*	3*	2 ½*	3"	2 ½"	3*
RHX2A019	2/0	19	.650*	100 mils	537	175	195	2 %*	3*	2 1/2*	3"	2 %"	3*
RHX3A019	3/0	19	.700*	100 mils	658	200	225	3"	3 1/2*	3*	3 %*	3"	3 %*
RHX4A019	4/0	19	.760*	100 mils	806	230	260	3"	3 ½*	3*	3 %*	3"	3 %*
RH250A037	250 MCM	37	.865*	130 mils	991	255	290	3 ½*	4*	3*	3 %*	3"	4*
RH300A037*	300 MCM	37	.920"	130 mils	1165	285	320	4"	4*	3 ½*	4"	3 %"	4****
RH350A037	350 MCM	37	.970*	130 mils	1306	310	350	4*	4*	3 1/2*	4"	3 1/2"	4
RH400A037*	400 MCM	37	1.020"	130 mils	1672	335	380	4"	х	4*	х	4"	х
RH500A037	500 MCM	37	1.105*	130 mils	1825	380	430	4"	х	4*	х	4"	x

Protective System (FHIT/7) #28E and all provisions of the National Electrical Code (NFPA 70). Ampacity based on three current

A1. A 3-inch EMT shall be used as suggested by the RFI. Refer to the updated drawing sheet E-601.00 (attached).

- Q2. I am working on getting everything together for the bid for the FIT Pomerantz Center New Fire Alarm System Rebid (Alt) Project. If possible, please confirm the following:
 - (a) There are no Liquidated Damages.
 - (b) There is no Bid Bond Form.

(c) The Bid Packet must be emailed to this email address by 12:00 Noon on Thursday, June 26, 2025. It cannot be dropped off or mailed. The only portion of the bid that can be dropped off or mailed is the Bid Security (if there is one).

- A2a. There are no liquidated damages.
- A2b. We don't provide bid bond forms, it's something that you'll need to get from your bonding company. Each bonding company might use a different form. In the past, some bidders submitted a Document A310 with their bid from their bonding company.
- A2c. Yes, the bid package must be emailed to <u>purchasingbids@fitnyc.edu</u> on or before 12:00pm on June 26, 2025. The emailed bid package must contain an image of the bid security (certified check of 2% or bid bond of 10% of your total bid price). The original copy of the bid security can be dropped of at 333 7th Ave. 16th Fl, New York, NY 10001, or mailed to 227 West 27th St. New York, NY 10001.


THIS ADDENDUM IS PART OF THE CONTRACT DOCUMENT AND SHALL BE INCLUDED WITH YOUR BID SUBMITTAL. YOUR SIGNATURE BELOW WARRANTS THAT YOU UNDERSTAND THIS ADDENDUM AND THAT YOU HAVE MADE THE APPRORIATE ADJUSTMENTS IN YOUR BID AND CALCULATIONS.


Signature

Print Name and Title of Authorized Representative

Print Name of Company/Partnership/Individual

Date

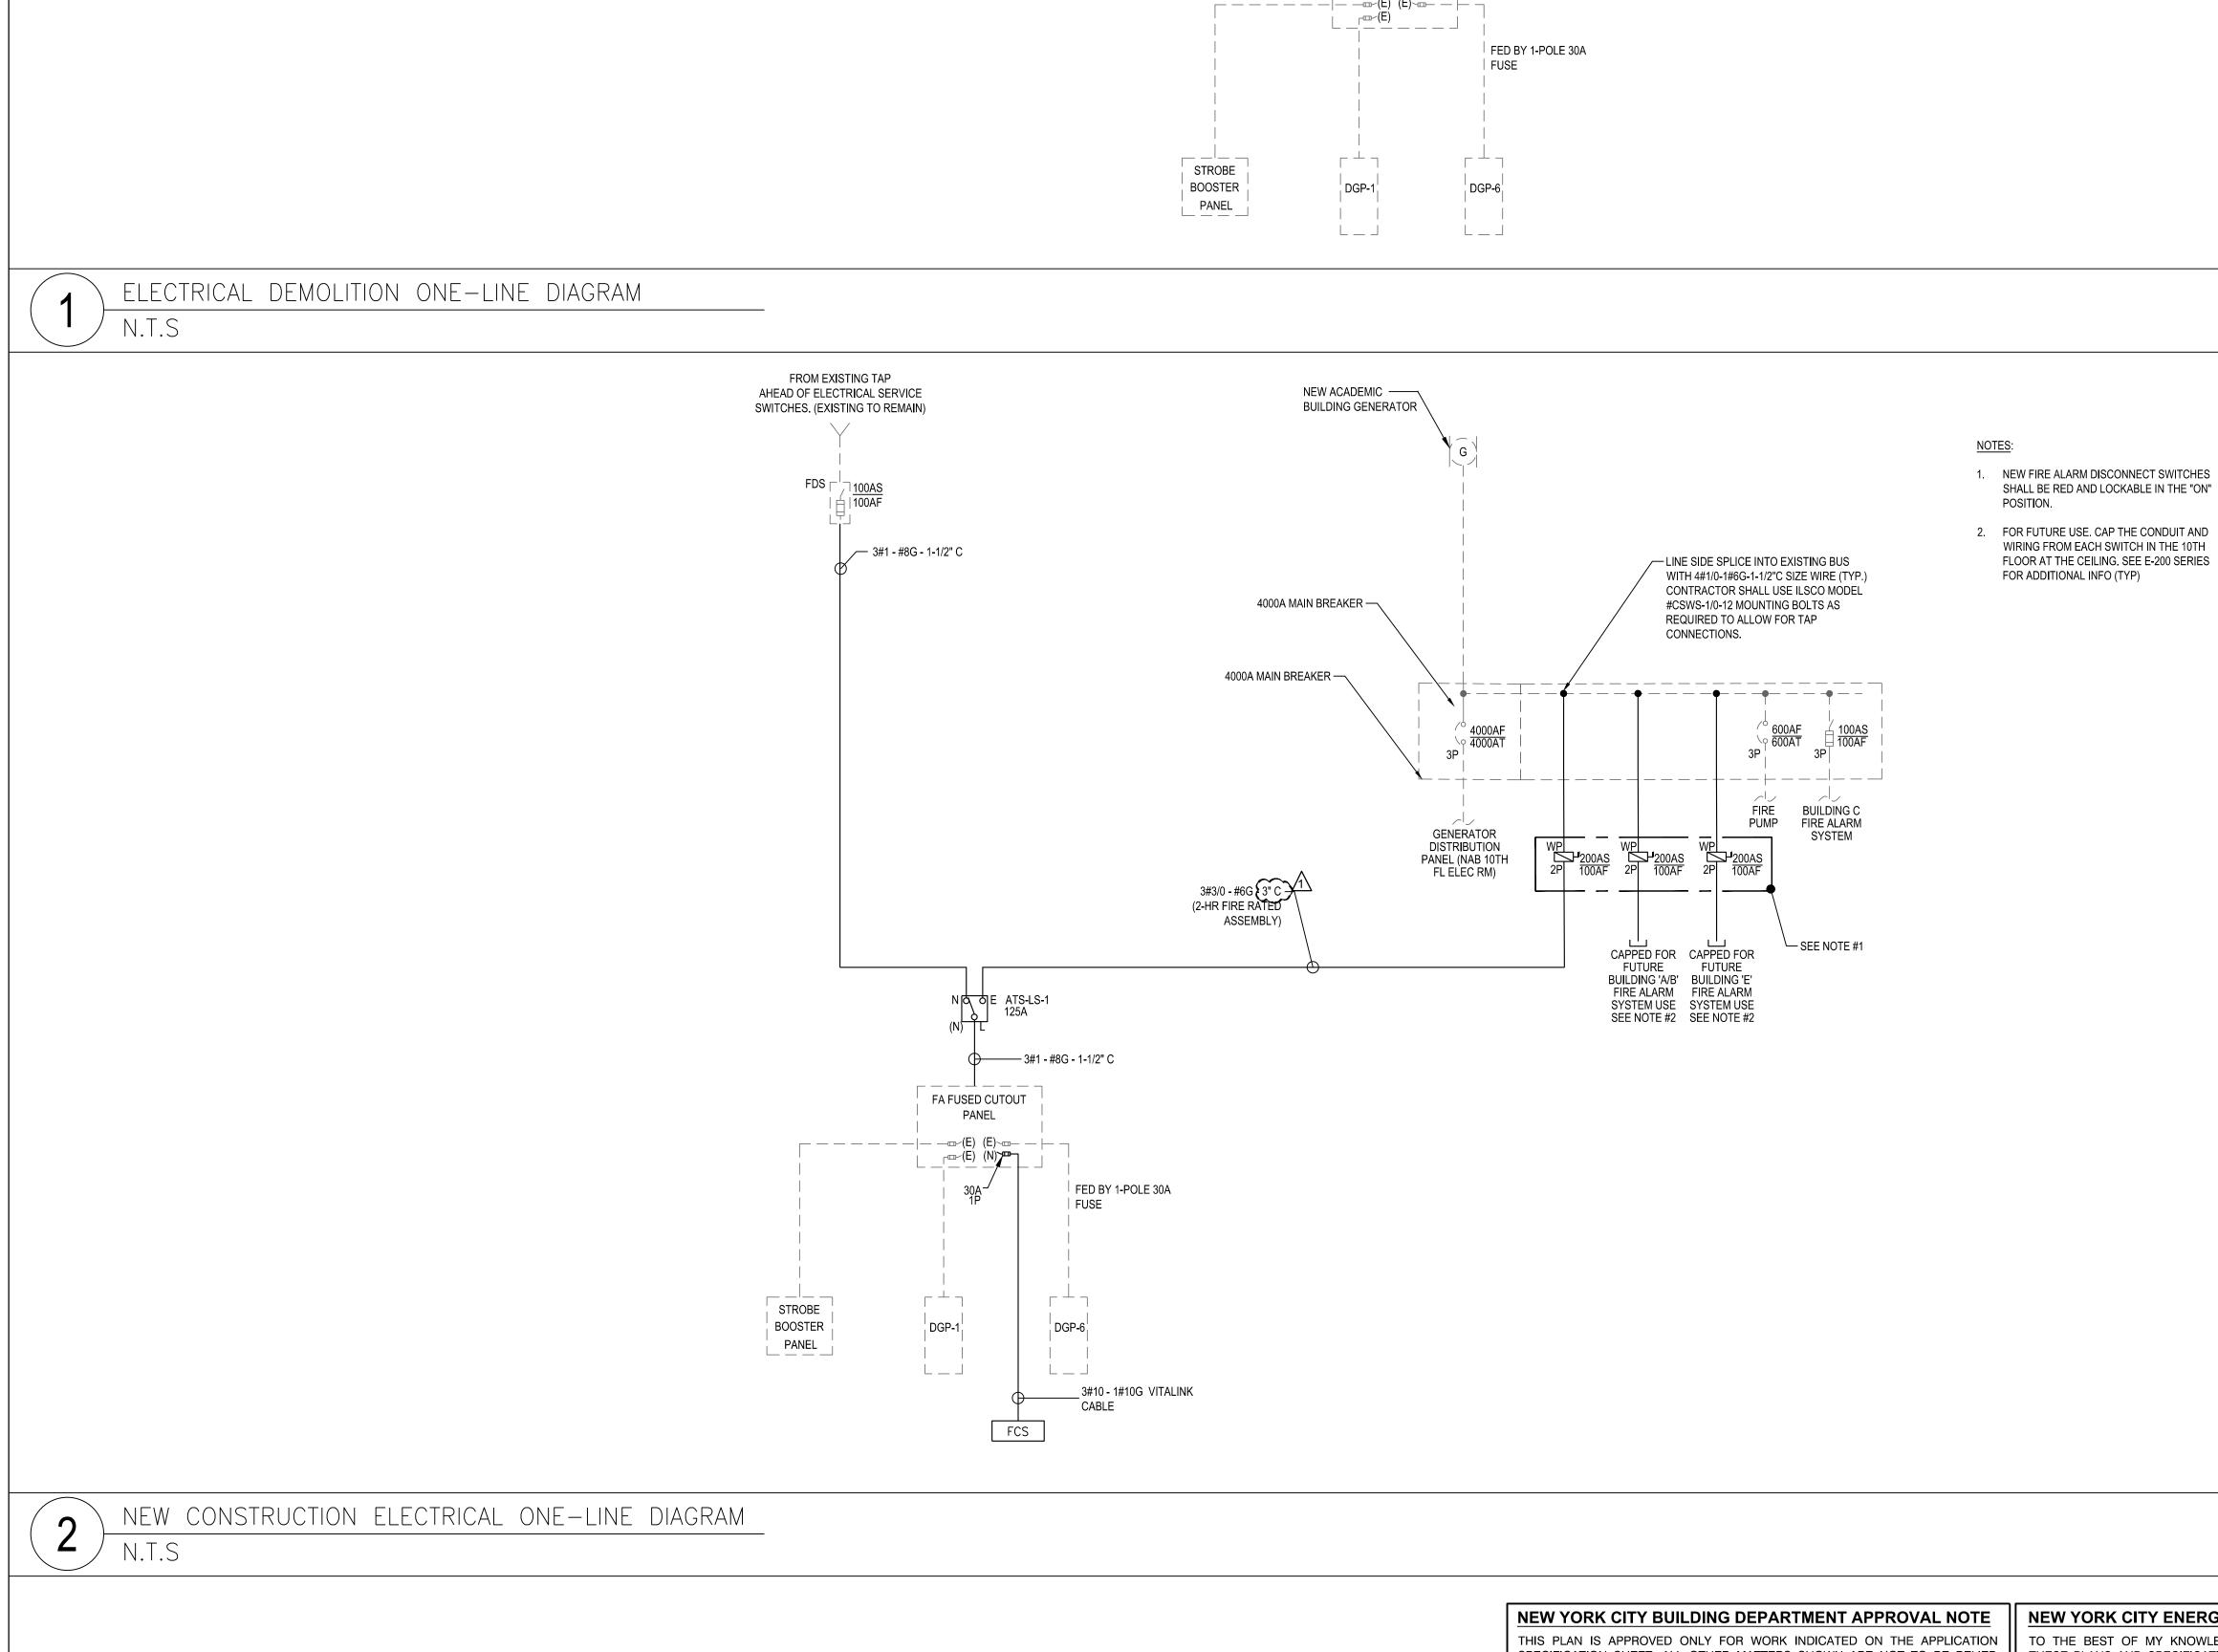

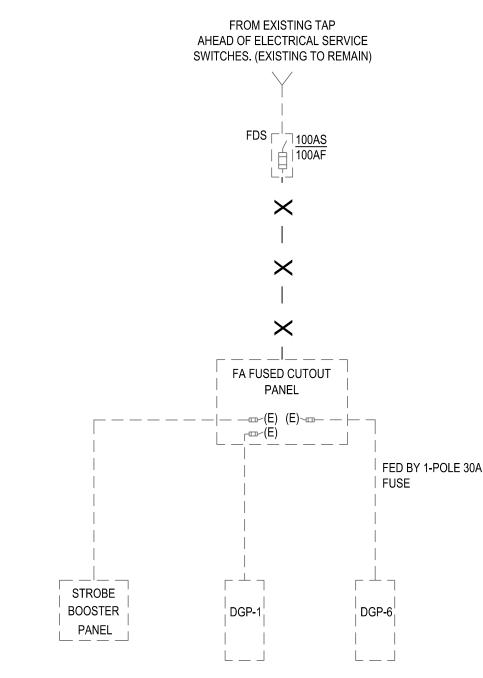

THIS PLAN IS APPROVED ONLY FOR WORK INDICATED ON THE APPLICATION SPECIFICATION SHEET. ALL OTHER MATTERS SHOWN ARE NOT TO BE RELIED UPON, OR TO BE CONSIDERED AS EITHER BEING APPROVED OR IN ACCORDANCE WITH APPLICABLE CODES.

NEW YORK CITY ENERGY CC TO THE BEST OF MY KNOWLEDGE, I THESE PLANS AND SPECIFICATIONS A YORK CITY ENERGY CONSERVATION CO

SHALL BE RED AND LOCKABLE IN THE "ON"

FLOOR AT THE CEILING. SEE E-200 SERIES

FOR ADDITIONAL INFO (TYP)

POSITION.

		NEST 20TH STREET NEST 20TH ST					
	MG 116 New Env EPN 1983	06/19/2025 06/02/2025 06/02/2025 DATE P Consultants Engineering West 32nd S Vest 32nd S	D.P.C. treet, 0001 onsultants	BID			
	Fashion Institute of Technology 227 West 27th Street New York, NY 10001 David Smotrich & Partners LLP Architects/Planers 443 Park Avenue South New York, NY 10016 212 889 4045 Fax 212 889 3672						
	PRO.	PROJECT: POMERANTZ DESIGN CENTER FIRE ALARM SYSTEM 300 7TH AVENUE NEW YORK, NY, 10001 DRAWING TITLE: ELECTRICAL ONE-LINE DIAGRAMS					
DISERVATION CODE BELIEF AND PROFESSIONAL JUDGMENT, ARE IN COMPLIANCE WITH THE 2020 NEW DDE. DEC. / we engineer success 16 West 32nd Street, 12th Floor, New York, N.Y. 10001 212.643.9055 www.mgedpc.net	SEAL	& SIGNATURE	Ξ: 2	DATE: 06.02.2025 PROJECT No: 8969.74 DRAWING BY: DG CHK BY: CTD SCALE: N.T.S DWG No: E-601.00 CADD FILE: DOB page: 4 OF 7			